

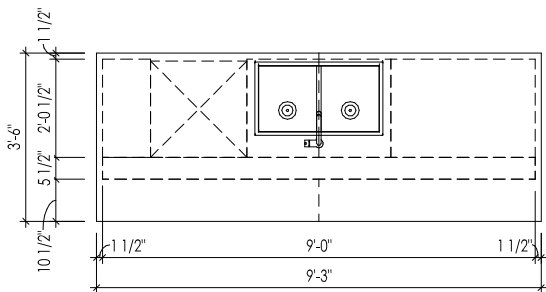


I:\Projects\2023\1801 HOLSTON MEADOW PL\BSTRN\023-00\023-00.dwg

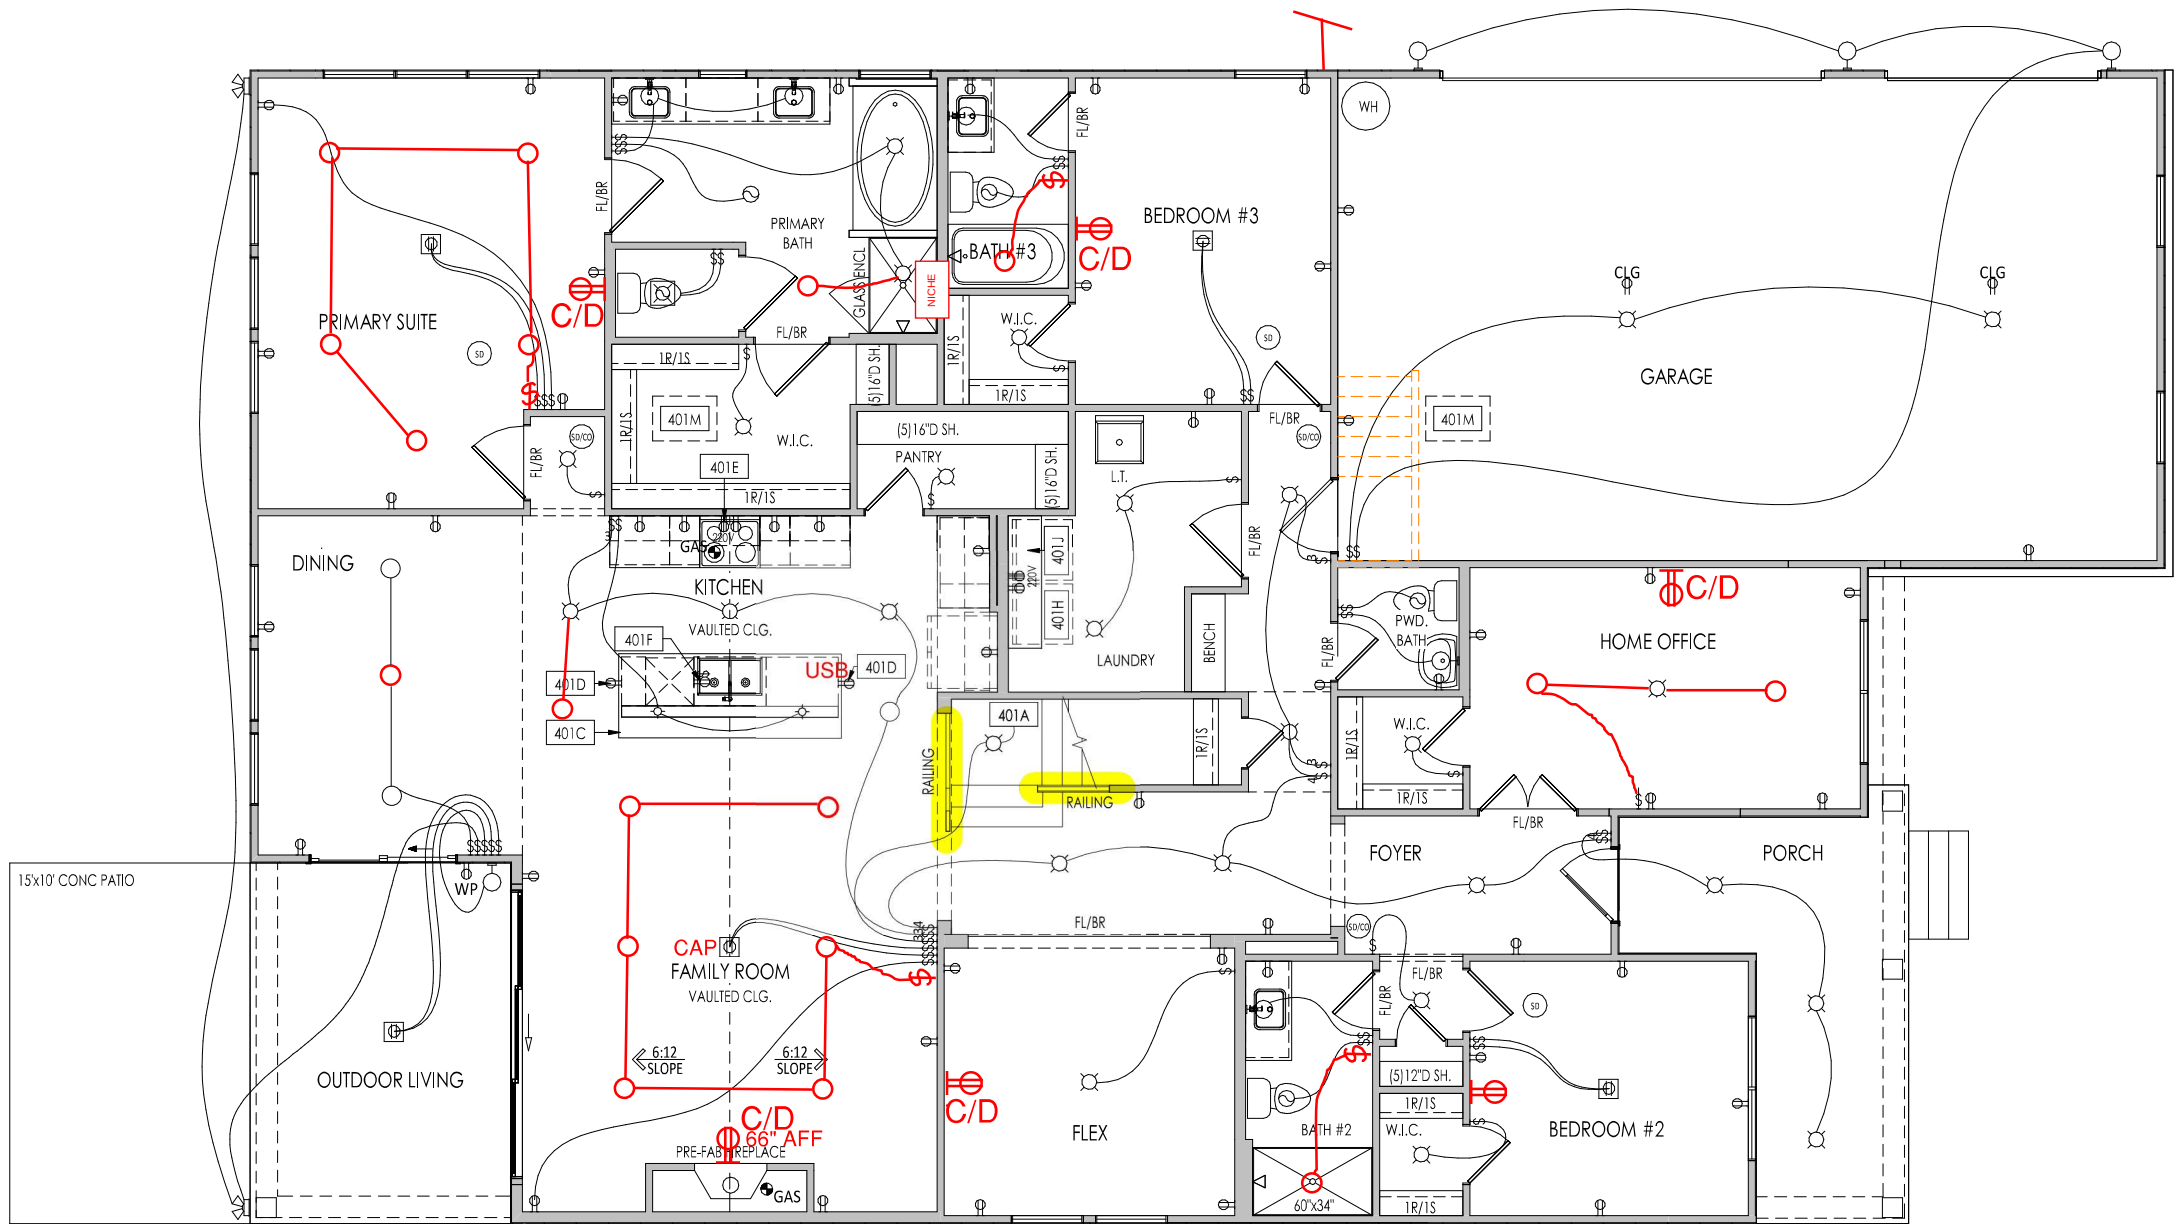

A
4.01
KITCHEN ISLAND DETAIL
1/4" = 1'-0"

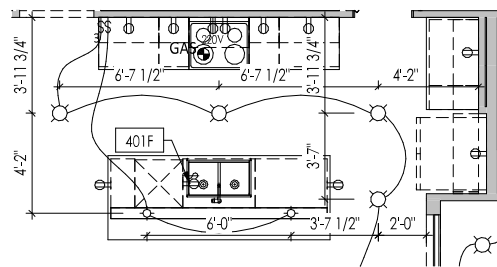

B
4.01
KITCHEN LIGHTING DETAIL
1/8" = 1'-0"

General Notes:

1. REFER TO SHEET ON.1 FOR GENERAL NOTES.

Key Notes:

401A	TO SWITCH OR LIGHT ABOVE
401C	SEE DETAIL A/4.01 FOR KITCHEN ISLAND COUNTERTOP DIMENSIONS
401D	HOLD OUTLET HIGH ON ISLAND
401E	OUTLET FOR RANGE HOOD/MICROWAVE HELD HIGH - VENT TO EXTERIOR
401F	OUTLET FOR DISHWASHER LOCATED IN SINK CABINET
401H	LOCATE WASHER TO LEFT OF DRYER
401J	UPPER WALL CABINETS OR 16" DEEP x 5'-6" LONG SHELF HELD AT 5'-7" A.F.F. - REFER TO SELECTIONS
401M	22-1/2" x 32" ATTIC ACCESS PANEL IN CEILING

MECHANICAL LEGEND

⊖ WALL OUTLET	⊖ CLG. MOUNTED LIGHT FIXT.	⊖ HOSE BIB
⊖ WEATHERPROOF GFCI OUTLET	⊖ SURFACE MOUNT DISC LIGHT OR RECESSED CEILING LIGHT, PER SPECS.	⊖ SHOWER HEAD
⊖ 220 VOLT OUTLET	⊖ WALL MOUNTED LIGHT FIXT.	⊖ GAS HOOK UP
⊖ GFCI OUTLET	⊖ DOUBLE SPOTLIGHT FIXT.	⊖ FLOOR DRAIN
⊖ FLOOR OUTLET	⊖ DIRECTIONAL CAN LIGHT	⊖ SMOKE DETECTOR
⊖ COUNTER POP-UP OUTLET	⊖ PIN LIGHT	⊖ SMOKE DETECTOR/CO DETECTOR COMBINATION
⊖ SINGLE POLE SWITCH	⊖ WALL SCONCE @ 5'-6" A.F.F.	⊖ EXHAUST FAN AND LIGHT COMBINATION
⊖ 3-WAY SWITCH	⊖ FLUORESCENT LIGHT	⊖ CLG. MTD. EXHAUST FAN
⊖ 4-WAY SWITCH	⊖ UNDER CABINET LIGHTING	⊖ DATA JACK
⊖ STAIR LIGHT		⊖ CABLE TELEVISION JACK
⊖ BLOCK, MOUNT, & SWITCH FOR FUTURE FAN/LIGHT COMBINATION (CENTER, UNLESS OTHERWISE NOTED)		

Space for Architect Seal

RESIDENCE FOR:
MARKET
1801 HOLSTON MEADOW PL
BRISTOL RUN

Job Number: BSTN-0023-00	Drawing Date: 4.22.26	Coord Name: G. PIEPER	Coord Phone: 859.578.4355
------------------------------------	---------------------------------	---------------------------------	-------------------------------------

House Name:	Drawing Scale: 1/8" = 1'-0"	Contract Drawn By: IDB
-------------	-----------------------------	----------------------------------

the PARKETTE

Standard House 3D Model Link: XXXX

Drees
HOMES
Copyright © 2023 (2026) The Drees Company. All Rights Reserved.
8521 Six Forks Road, Suite 500, Raleigh, NC 27615
Phone: (919) 844-9288


Born on Date:
07/11/23
CDs Drawn By:
CLM

4.01

First Floor Mechanical Plan
Elevation "D"

4/23/2026 4:10:40 PM

I:\Clients\SE\Southeast\RALEIGH\BSTN\BSTN-0023-00\BSTN-0023-00.rvt

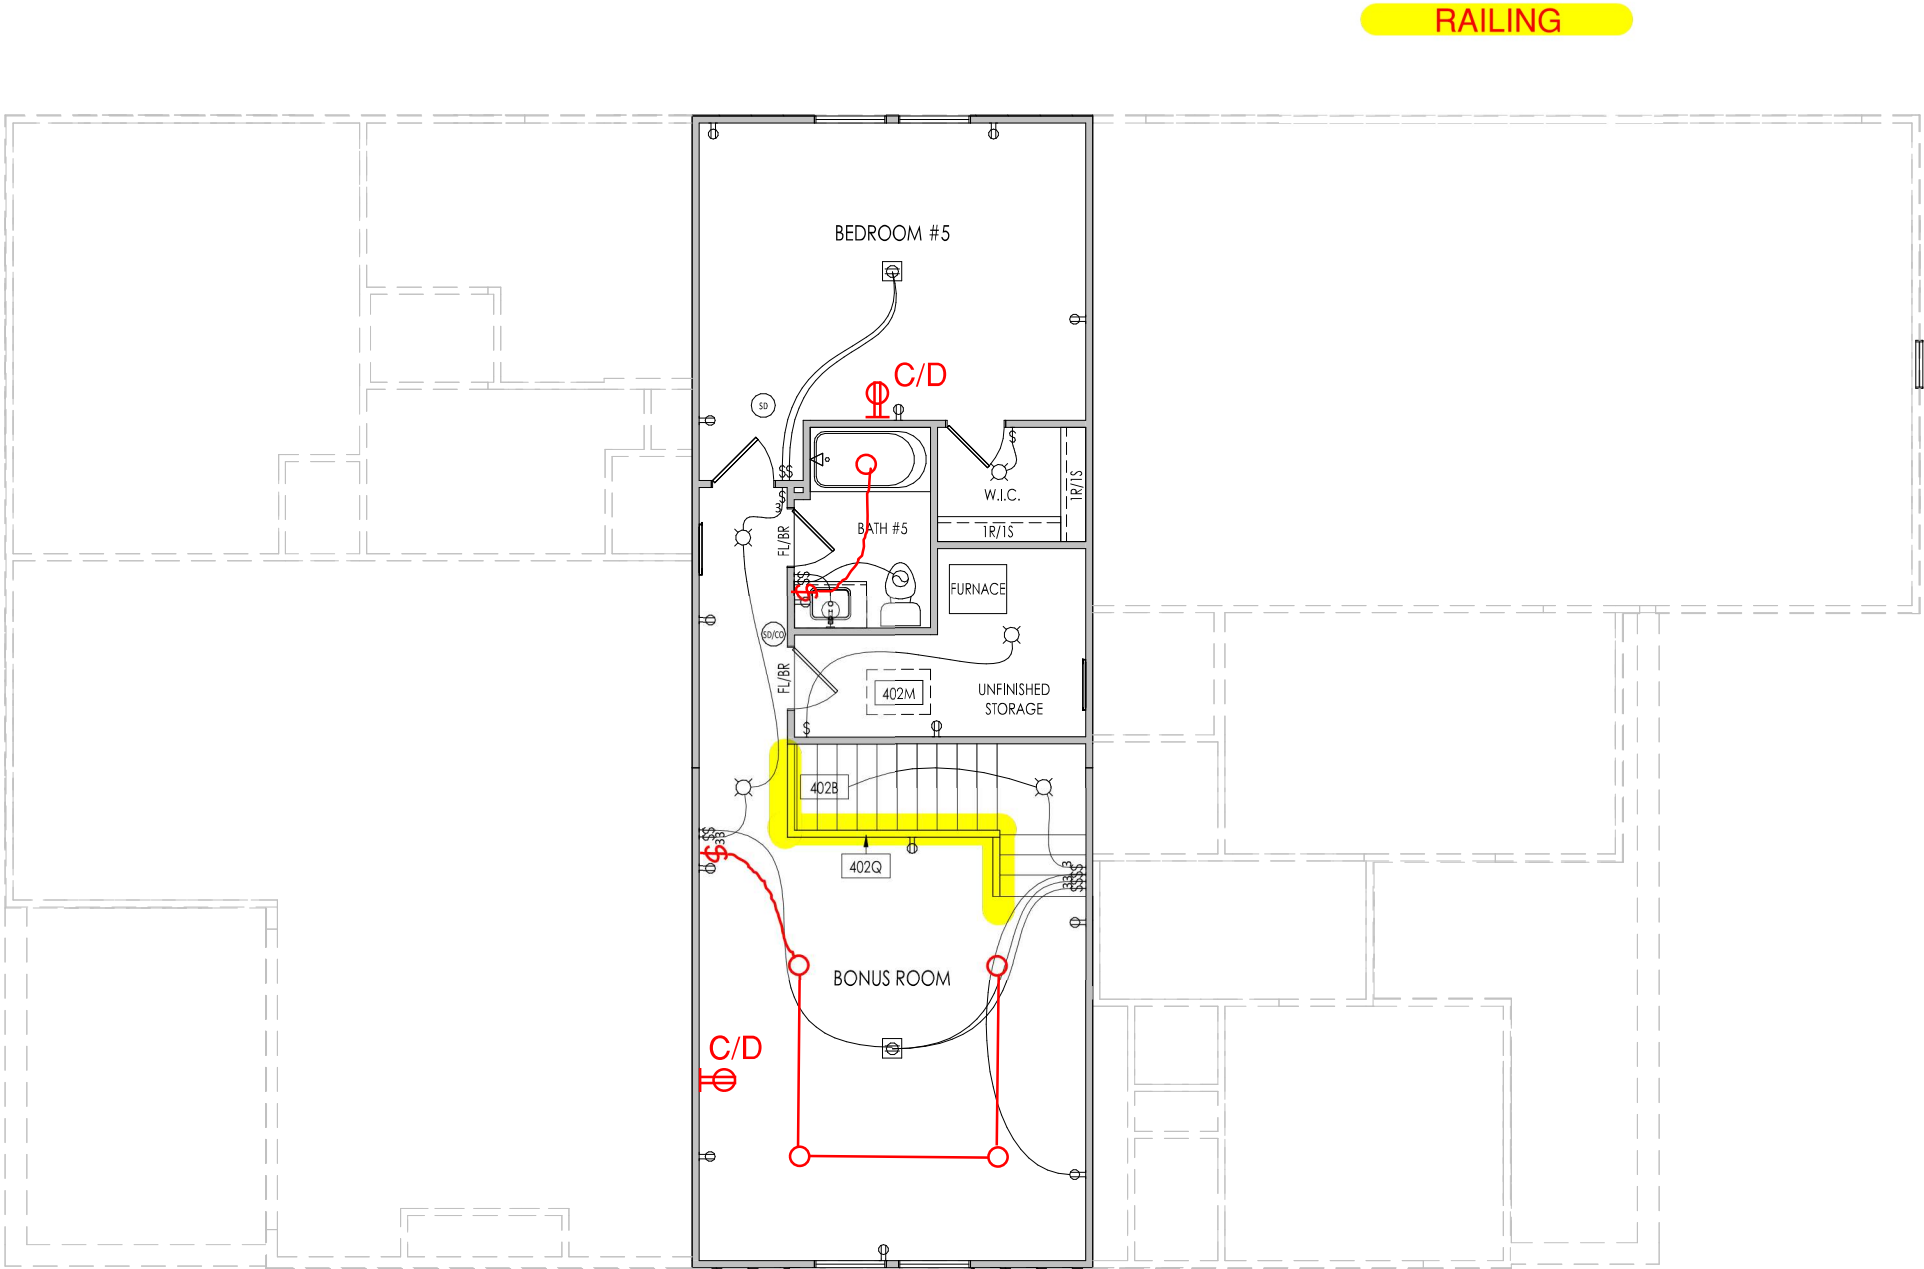

General Notes:

1. REFER TO SHEET ON.1 FOR GENERAL NOTES.

Key Notes:

402B TO SWITCH OR LIGHT BELOW

402M 22-1/2" x 32" ATTIC ACCESS PANEL IN CEILING

402Q 36" HIGH WALL W/ WOOD CAP

MECHANICAL LEGEND

- | | | |
|--------------------------|--|--|
| WALL OUTLET | CLG. MOUNTED LIGHT FIXT. | HOSE BIB |
| WEATHERPROOF GFCI OUTLET | SURFACE MOUNT DISC LIGHT OR RECESSED CEILING LIGHT, PER SPECS. | SHOWER HEAD |
| 220 VOLT OUTLET | WALL MOUNTED LIGHT FIXT. | GAS GAS HOOK UP |
| GFCI OUTLET | DOUBLE SPOTLIGHT FIXT. | FLOOR DRAIN |
| FLOOR OUTLET | DIRECTIONAL CAN LIGHT | SMOKE DETECTOR |
| COUNTER POP-UP OUTLET | PIN LIGHT | SMOKE DETECTOR/CO DETECTOR COMBINATION |
| SINGLE POLE SWITCH | WALL SCONCE @ 5'-6" A.F.F. | EXHAUST FAN AND LIGHT COMBINATION |
| 3-WAY SWITCH | FLUORESCENT LIGHT | CLG. MTD. EXHAUST FAN |
| 4-WAY SWITCH | UNDER CABINET LIGHTING | DATA JACK |
| STAIR LIGHT | BLOCK, MOUNT, & SWITCH FOR FUTURE FAN/LIGHT COMBINATION (CENTER, UNLESS OTHERWISE NOTED) | CABLE TELEVISION JACK |

Space for Architect Seal

RESIDENCE FOR:

MARKET
1801 HOLSTON MEADOW PL
BRISTOL RUN

Job Number:	Drawing Date:	Coord Name:	Coord Phone:
BSTN-0023-00	4.22.26	G. PIEPER	859.578.4355

House Name:	Drawing Scale: 1/8" = 1'0"	Contract Drawn By:
		IDB

the PARKETTE	Series:
	EXECUTIVE

Standard House 3D Model Link: XXXX	Plan No.:
------------------------------------	-----------

 Copyright © 2023 (2026) The Drees Company. All Rights Reserved. 8521 Six Forks Road, Suite 500, Raleigh, NC 27615 Phone: (919) 844-9288	Born on Date: 07/11/23	CDs Drawn By: CLM
	Sheet Information 4.02 Second Floor Mechanical Plan Elevation "D"	

4/23/2026 4:10:40 PM