


STAIR RAILING

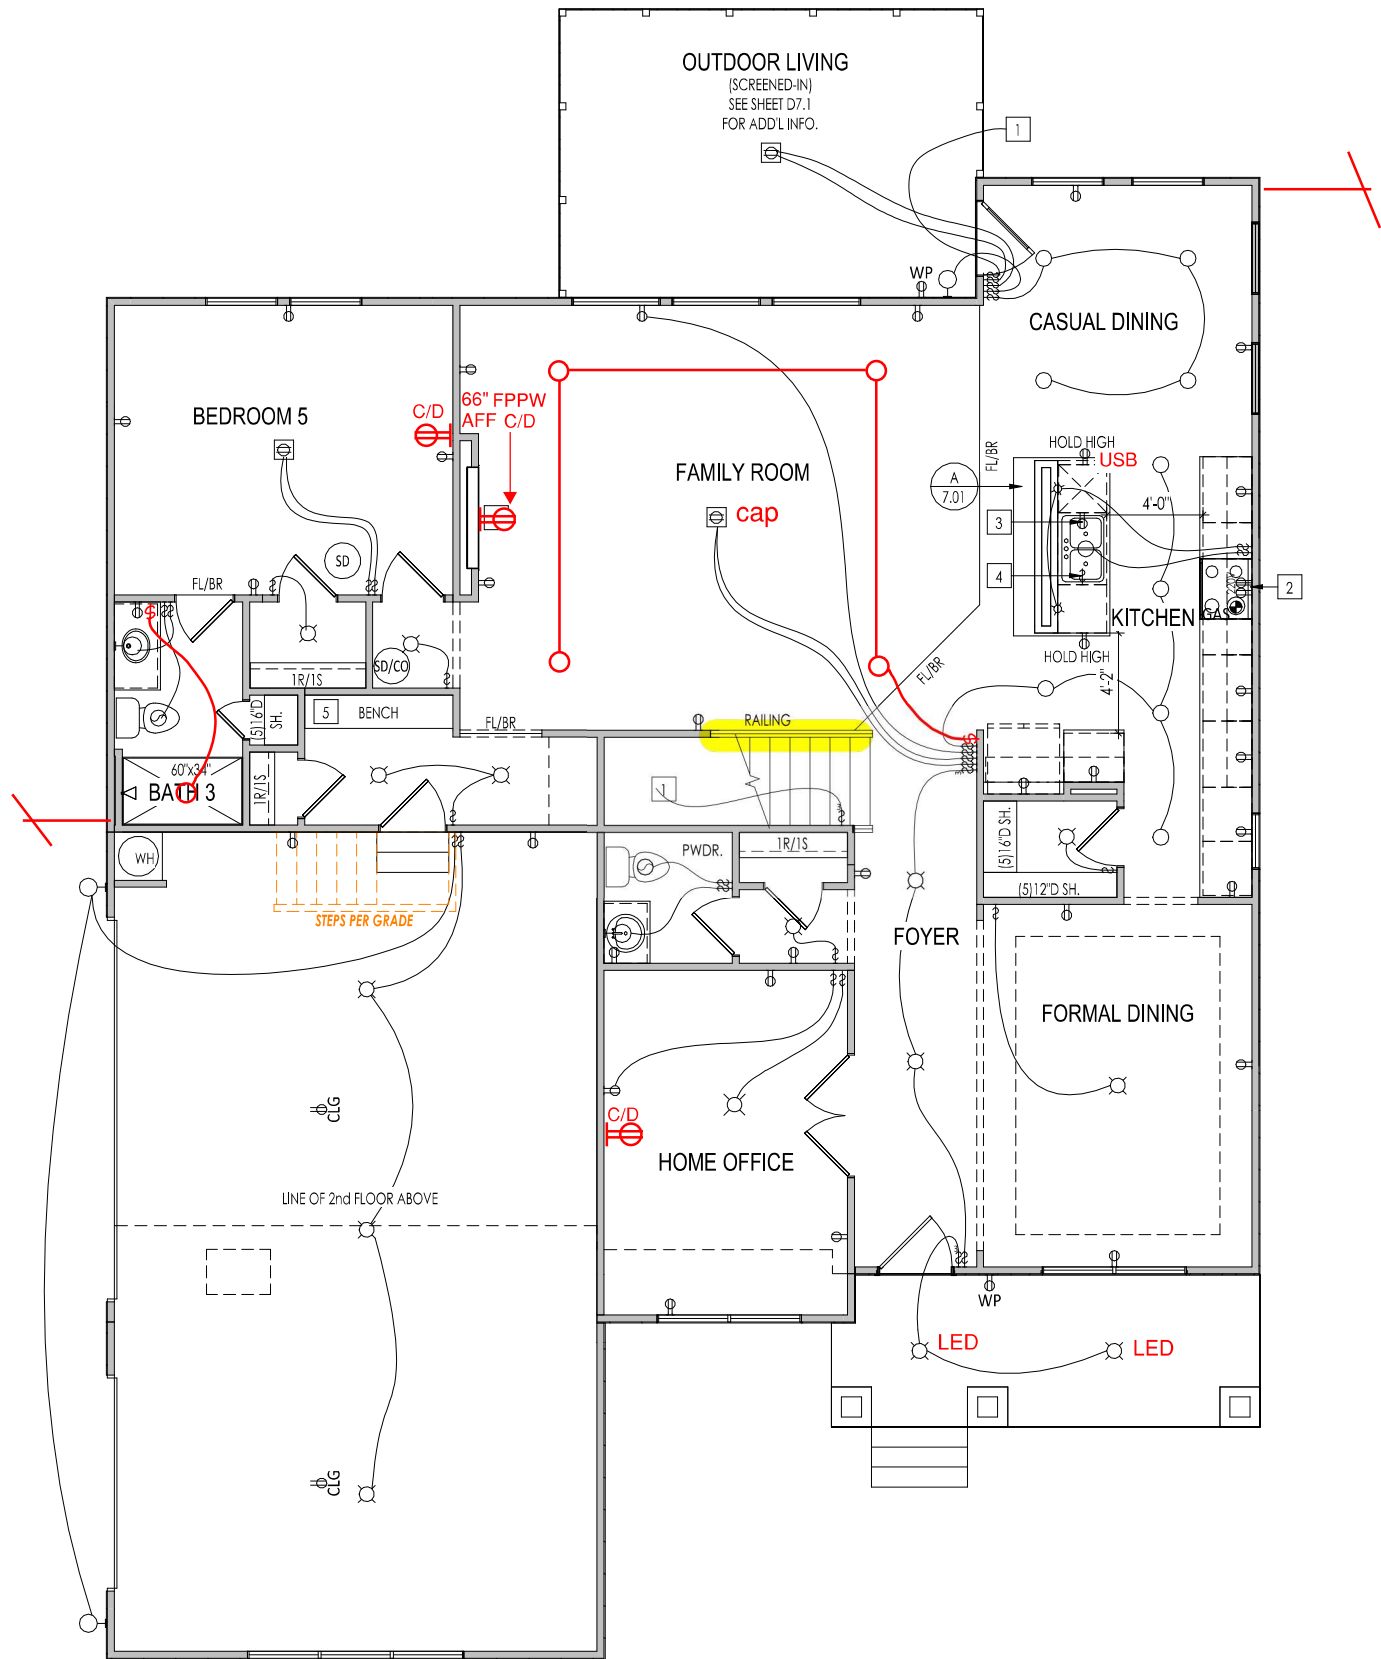

General Notes:

1. REFER TO SHEET 0N.1 FOR GENERAL NOTES.

Key Notes:

- 1 TO SWITCH OR LIGHT ABOVE
- 2 OUTLET FOR RANGE HOOD/MICROWAVE HELD HIGH
- 3 OUTLET FOR DISHWASHER LOCATED IN SINK CABINET
- 4 DISPOSAL SWITCH IN SINK CABINET
- 5 BENCH SEAT: SEE STANDARD DETAILS F/D2.2 FOR MORE INFORMATION
- 6 PRE-FABRICATED ELECTRIC FIREPLACE
- 7
- 8
- 9
- 10 --

MECHANICAL LEGEND

WALL OUTLET	CLG. MOUNTED LIGHT FIXT.	HOSE BIB
WEATHERPROOF GFCI OUTLET	SURFACE MOUNT DISC LIGHT OR RECESSED CEILING LIGHT, PER SPECS.	SHOWER HEAD
220 VOLT OUTLET	WALL MOUNTED LIGHT FIXT.	GAS GAS HOOK UP
GFCI OUTLET	DOUBLE SPOTLIGHT FIXT.	FLOOR DRAIN
FLOOR OUTLET	DIRECTIONAL CAN LIGHT	SMOKE DETECTOR
COUNTER POP-UP OUTLET	PIN LIGHT	SMOKE DETECTOR/CO DETECTOR COMBINATION
SINGLE POLE SWITCH	WALL SCONCE @ 5'-6" A.F.F.	EXHAUST FAN AND LIGHT COMBINATION
3-WAY SWITCH	FLUORESCENT LIGHT	CLG. MTD. EXHAUST FAN
4-WAY SWITCH	UNDER CABINET LIGHTING	DATA JACK
STAIR LIGHT	BLOCK, MOUNT, & SWITCH FOR FUTURE FAN/LIGHT COMBINATION (CENTER, UNLESS OTHERWISE NOTED)	CABLE TELEVISION JACK

Space for Architect Seal

NOTE: Receptacles and switches will be placed per code by the electrician and will not necessarily be located as depicted on this plan.

RESIDENCE FOR:

MARKET

--

HIGHLAND SUMMIT MARK'S CREEK

Job Number:	Drawing Date:	Coord Name:	Coord Phone:
HMCR-0020-00	2/9/26	GREG P.	859.578.4355

House Name:	Drawing Scale: 1/8" = 1'0"	Contract Drawn By:
		GLP

the VANDERBURGH

Series: CLASSIC

Plan No.: PLAN_NM

Standard House 3D Model Link:	Born on Date:	CDs Drawn By:
	10/01/18	SSP


Copyright © 2018 (2022) The Drees Company. All Rights Reserved.
8521 Six Forks Road, Suite 500, Raleigh, NC 27615
Phone: [919] 844-9288

Sheet Information

4.01

First Floor Mechanical Plan
Elevation 'N'

HALF WALL

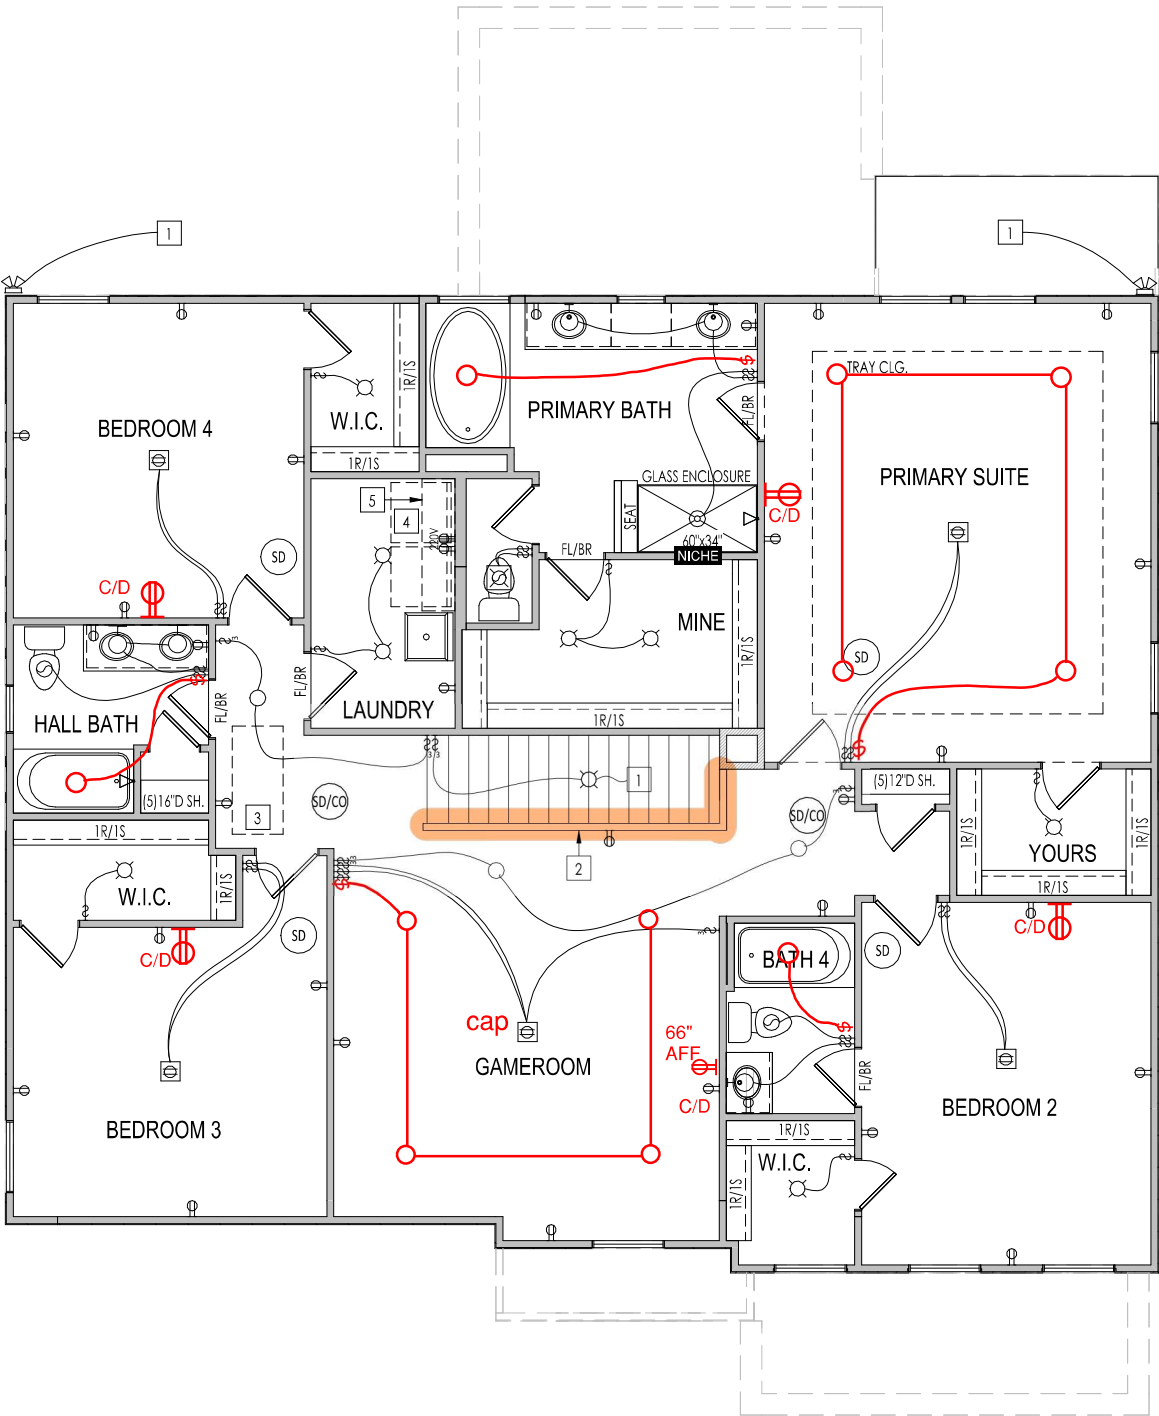

General Notes:

1. REFER TO SHEET ON.1 FOR GENERAL NOTES.

Key Notes:

- 1
- TO LIGHT OR SWITCH BELOW
- 2
- 36" HIGH WALL W/ WOOD CAP
- 3
- PULL DOWN 22-1/2" x 54" ATTIC ACCESS W/ LIGHT AND OUTLET
- 4
- 5'6" SHELF @ 5'7" A.F.F.
- 5
- WASHER TO LEFT OF DRYER
- 6
-
- 7
-
- 8
-
- 9
-
- 10
-

MECHANICAL LEGEND

- WALL OUTLET

WEATHERPROOF GFCI OUTLET

220 VOLT OUTLET

GFCI OUTLET

FLOOR OUTLET

COUNTER POP-UP OUTLET

SINGLE POLE SWITCH

3-WAY SWITCH

4-WAY SWITCH

STAIR LIGHT

BLOCK, MOUNT, & SWITCH FOR FUTURE FAN/LIGHT COMBINATION (CENTER, UNLESS OTHERWISE NOTED)
- CLG. MOUNTED LIGHT FIXT.
- SURFACE MOUNT DISC LIGHT OR RECESSED CEILING LIGHT, PER SPECS.
- WALL MOUNTED LIGHT FIXT.
- DOUBLE SPOTLIGHT FIXT.
- DIRECTIONAL CAN LIGHT
- PIN LIGHT
- WALL SCONCE @ 5'-6" A.F.F.
- FLUORESCENT LIGHT
- UNDER CABINET LIGHTING

HOSE BIB

SHOWER HEAD

GAS GAS HOOK UP

FLOOR DRAIN

SMOKE DETECTOR

SMOKE DETECTOR/ CO DETECTOR COMBINATION

EXHAUST FAN AND LIGHT COMBINATION

CLG. MTD. EXHAUST FAN

DATA JACK

CABLE TELEVISION JACK

Space for Architect Seal

NOTE: Receptacles and switches will be placed per code by the electrician and will not necessarily be located as depicted on this plan.

RESIDENCE FOR:

MARKET

--

HIGHLAND SUMMIT MARK'S CREEK

Job Number:

HMCR-0020-00

Drawing Date:

2/9/26

Coord Name:

GREG P.

Coord Phone:

859.578.4355

House Name:

Drawing Scale: 1/8" = 1'0"

Contract Drawn By:

GLP

the VANDERBURGH

Series:

CLASSIC

Standard House 3D Model Link:

Plan No.:

PLAN_NM

Drees

HOMES

Copyright © 2018 (2022) The Drees Company. All Rights Reserved.
8521 Six Forks Road, Suite 500, Raleigh, NC 27615
Phone: [919] 844-9288

Born on Date:

10/01/18

CDs Drawn By:

SSP

Sheet Information

4.02

Second Floor Mechanical Plan
Elevation 'N'